

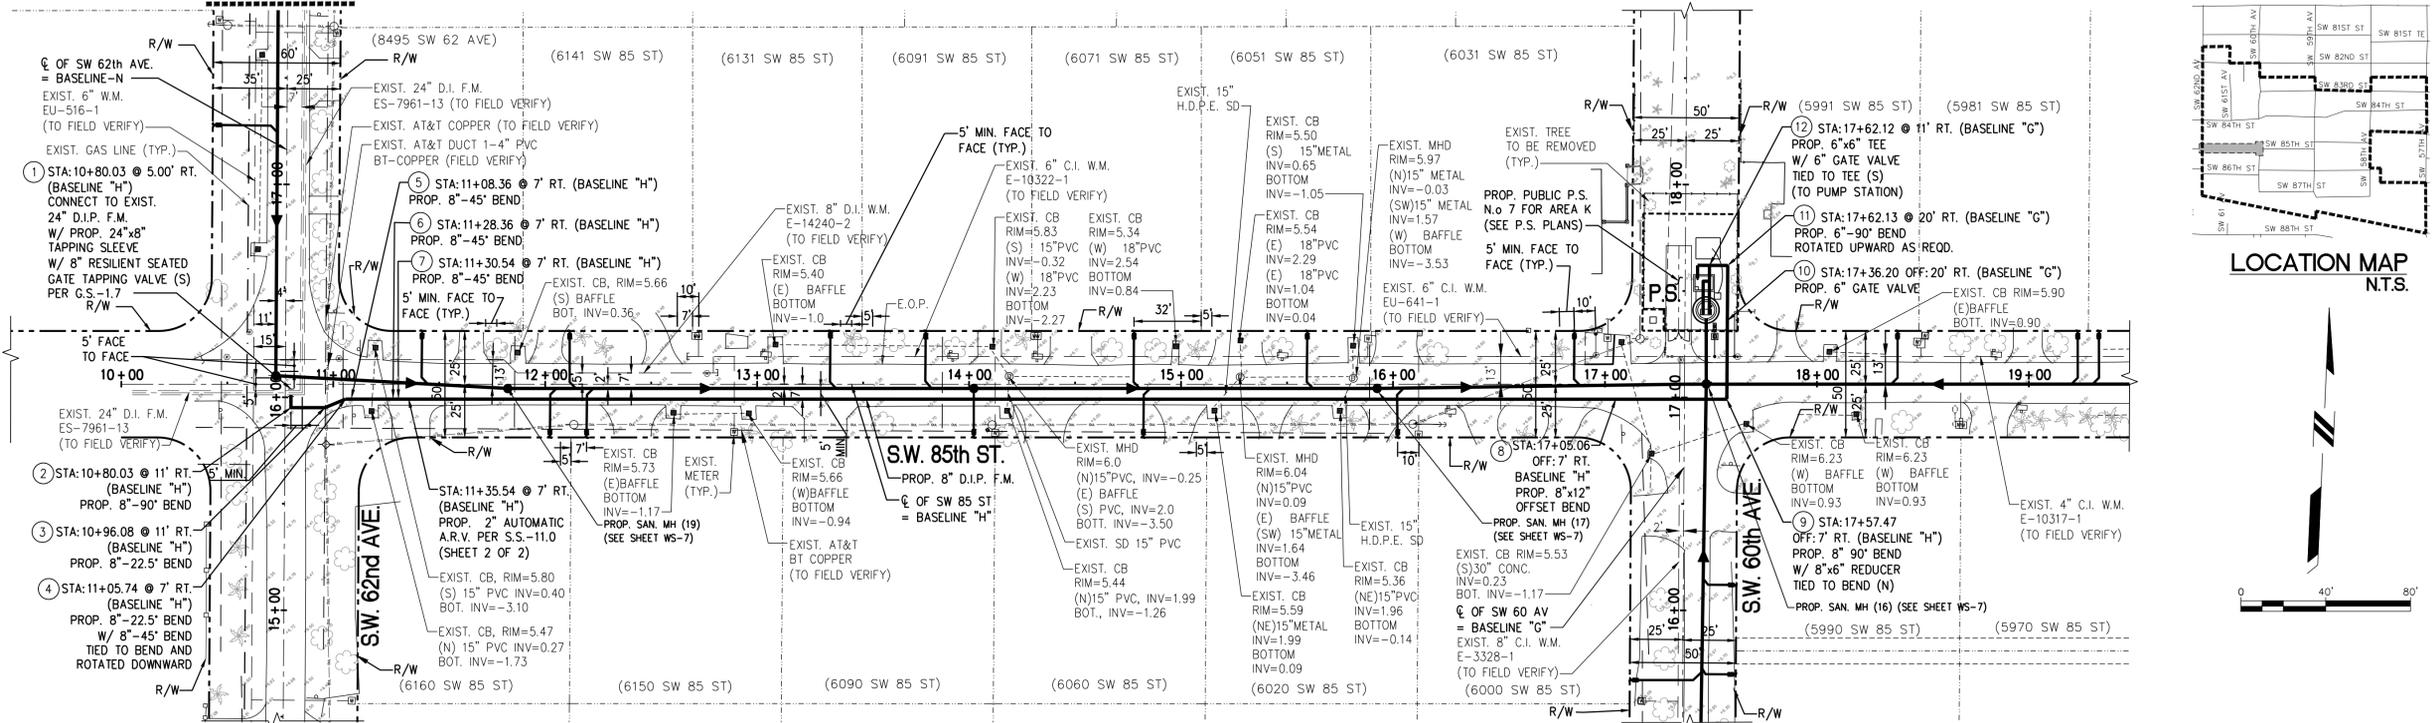
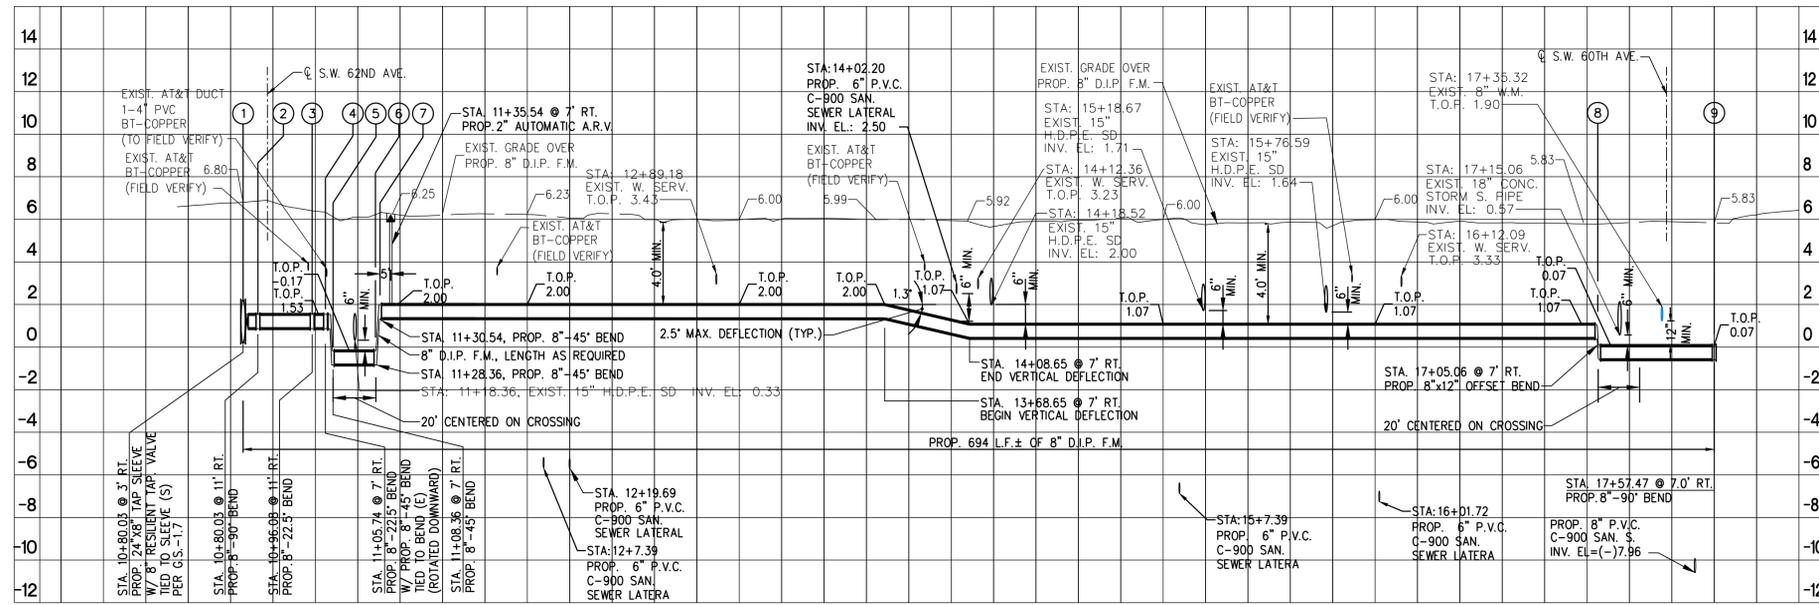



MATCH LINE FOR CONTINUATION  
SEE SHEET WS-13 (PHASE II)

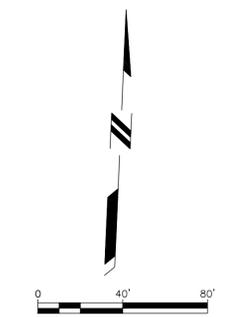

FORCE MAIN SYSTEM PLAN (SW 85TH STREET BASELINE-H)  
SCALE: 1" = 40'

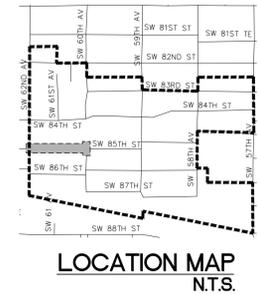

PROFILE FORCE MAIN (SW 85TH STREET BASELINE-H)  
SCALE: 1" = 40' HORIZ.  
SCALE: 1" = 4' VERT.

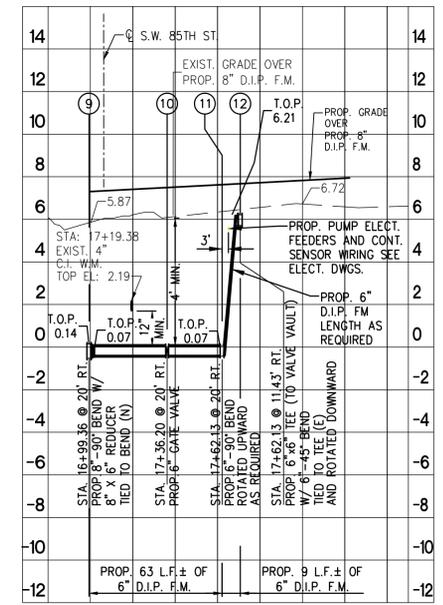

FORCE MAIN TO PUMP (BASELINE-G)  
SCALE: 1" = 40' HORIZ.  
SCALE: 1" = 4' VERT.

# PHASE I

**NOTE**

ALL D.I.P. PIPING TO BE ZINC COATED  
AND POLYETHYLENE ENCASED

MDWASD AGREEMENT SUB ID 22835  
MASTER ID 22796



PROJECT NAME:  
**CITY OF SOUTH MIAMI  
SUB AREA K SANITARY SEWER**  
CLIENT:  
CITY OF SOUTH MIAMI

SHEET TITLE:  
**FORCE MAIN PLAN AND PROFILE**



THIS ITEM HAS BEEN DIGITALLY SIGNED AND SEALED BY IGNACIO SERRANO, P.E. ON THE DATE ADJACENT TO THE SEAL. PRINTED COPIES OF THIS DOCUMENT ARE NOT CONSIDERED SIGNED AND SEALED AND THE SIGNATURE MUST BE VERIFIED ON ANY ELECTRONIC COPIES.

S.R.S. PROJ. NO.: 2317  
DATE: 11/27/2023  
DRAWN BY: A.S.  
DESIGNED BY: M.F.  
CHECKED BY: M.T.

no.	date	description

SHEET  
**WS-20**

LOCATED IN: F:\Engineering\SRS Projects\2023\2317 - South Miami Area K - Phase I\Design\2317-WS-20-FM-PROFILE.dwg & PRINTED ON: Monday, November 27, 2023, 11:28:58 AM